




B	CONSTRUCTION ISSUE	17.04.2026	JZ
REV N	DESCRIPTION	DATE	CHK'D

© Copyright Lucid Consulting Australia 9/09/2025 5:00:51 PM

CONSTRUCTION

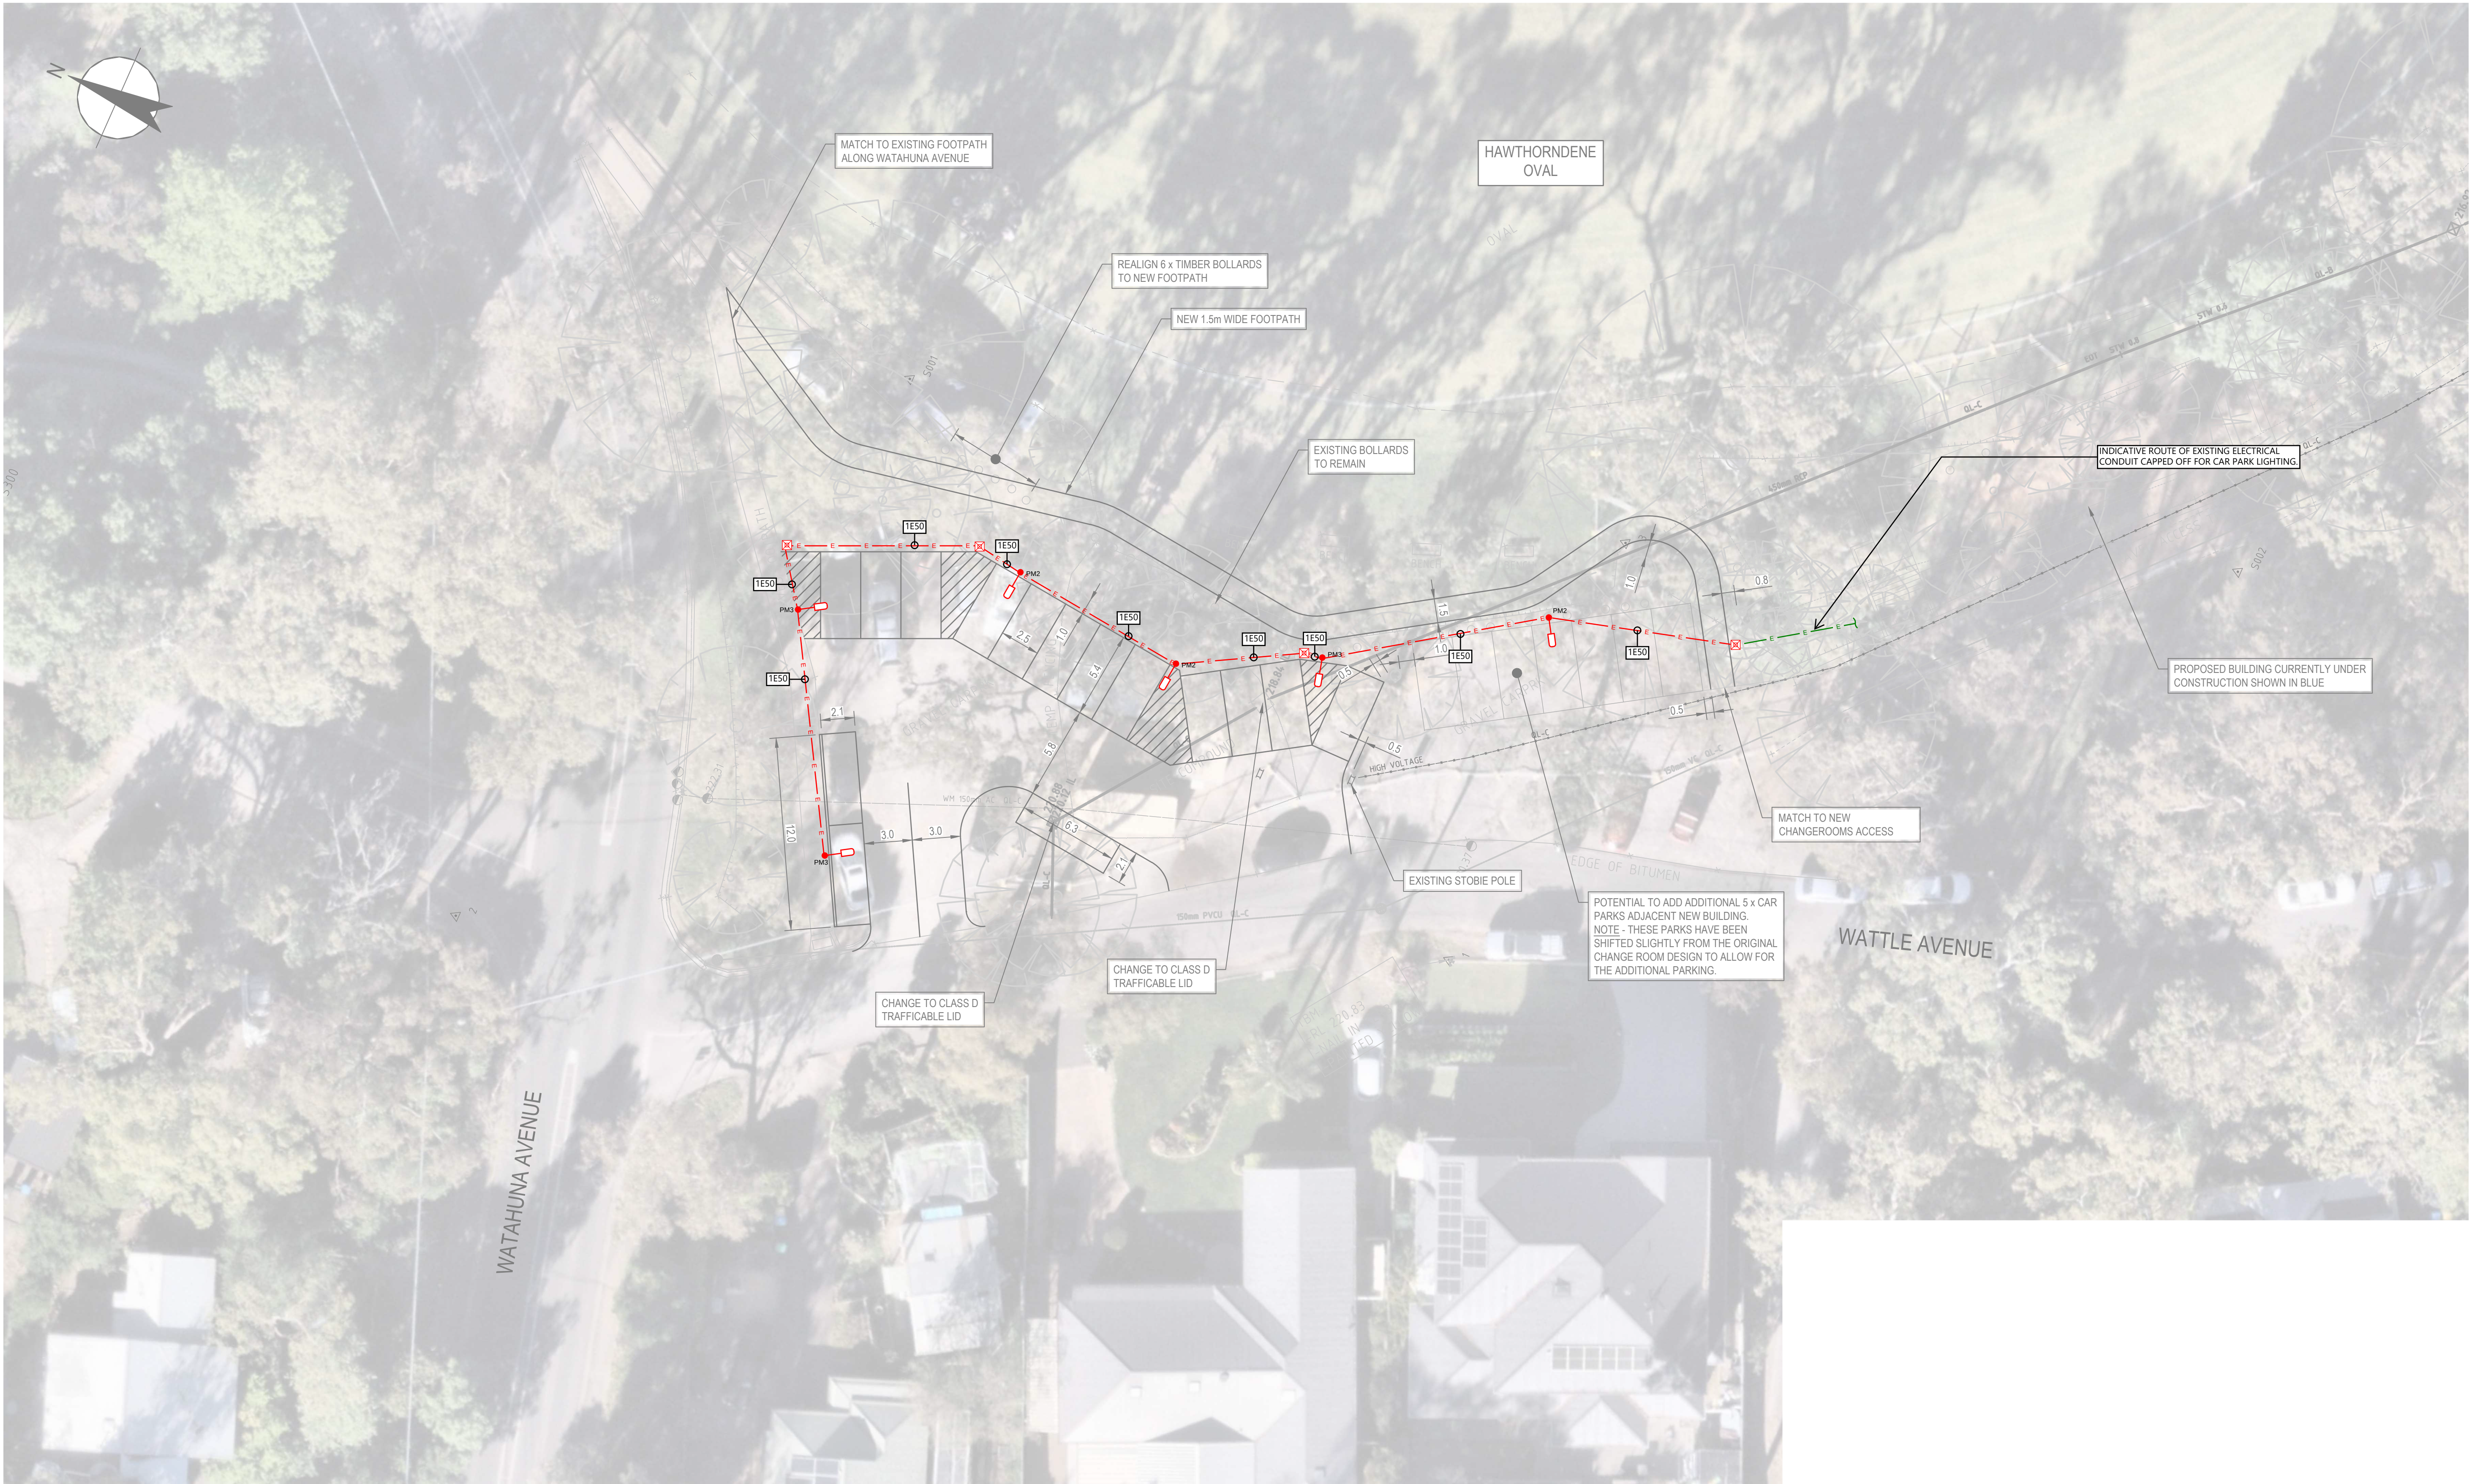

dasharchitects

LUCID

CONSULTING AUSTRALIA

Level 6, 80 Flinders Street
Adelaide SA 5000
Phone: (08) 8407 9700
Email: adelaide@lucidconsulting.com.au

PROJECT
HAWTHORNDENE OVAL CHANGEROOM
7 WATAHUNA AVENUE, HAWTHORNDENE SA 5051
ELECTRICAL SERVICES

DRAWING
PROPOSED CARPARK LIGHTING ARRANGEMENT

NOT FOR CONSTRUCTION PURPOSES UNLESS STAMPED FOR CONSTRUCTION. VERIFY DIMENSIONS AND LEVELS ON SITE BEFORE SETTING OUT. DO NOT SCALE. REFER TO FIGURED DIMENSIONS - IN mm UNLESS OTHERWISE STATED.

Scale	Design: RJ	No. in Set	Date
1:200	Drawn: ERA	4 OF 4	APR 2026
	Review: -		

Orig. Size	Drawing no.	Revision
A1	LCE21367-E300	B



ED VIA PE
AS/NZS 1158.

ED VIA PE
AS/NZS 1158.

Luminaire Schedule				
Symbol	Qty	Label	LLF	Description
	3	P1-T4	0.800	LIGMAN BILLUND -53W-BIU-90008-T4-8040
	3	P1-T2	0.800	LIGMAN BILLUND -53W-BIU-90008-T2-8040

This lighting design calculation is nominal and based on parameters provided by the client. Any design assumptions made and/or specific details determined by HI Lighting SA are noted in this document. In the case drawings files (dwg format) is not supplied to us. Scaling drawings from Pdf, Picture, Google maps cannot guarantee the accuracy of the size of area and may vary results of illuminated areas. Results in practice may be different due to variations such as luminaire positioning/aiming, surface reflectance, obstacles/furniture, etc. They are also subject to normally accepted photometric tolerances, and calculation/program uncertainties. HI Lighting SA shall be under no liability to the Customer for failure to attain such performance figures. Commercial in confidence.

CLIENT NAME :

LUCID CONSULTING

PROJECT NAME :

HAWTHORNDENE OVAL
CAR PARKING AREA

REV
0

DATE
10/04/2026

PREPARED FOR

HI LIGHTING SA
14-16 Bailey Street,
St Marys, SA, 5042
Tel: 08 8304 8500

CHECKED
BY
DATE

SCALE NTS
A1 PRINT SIZE
Page 1 of 4